
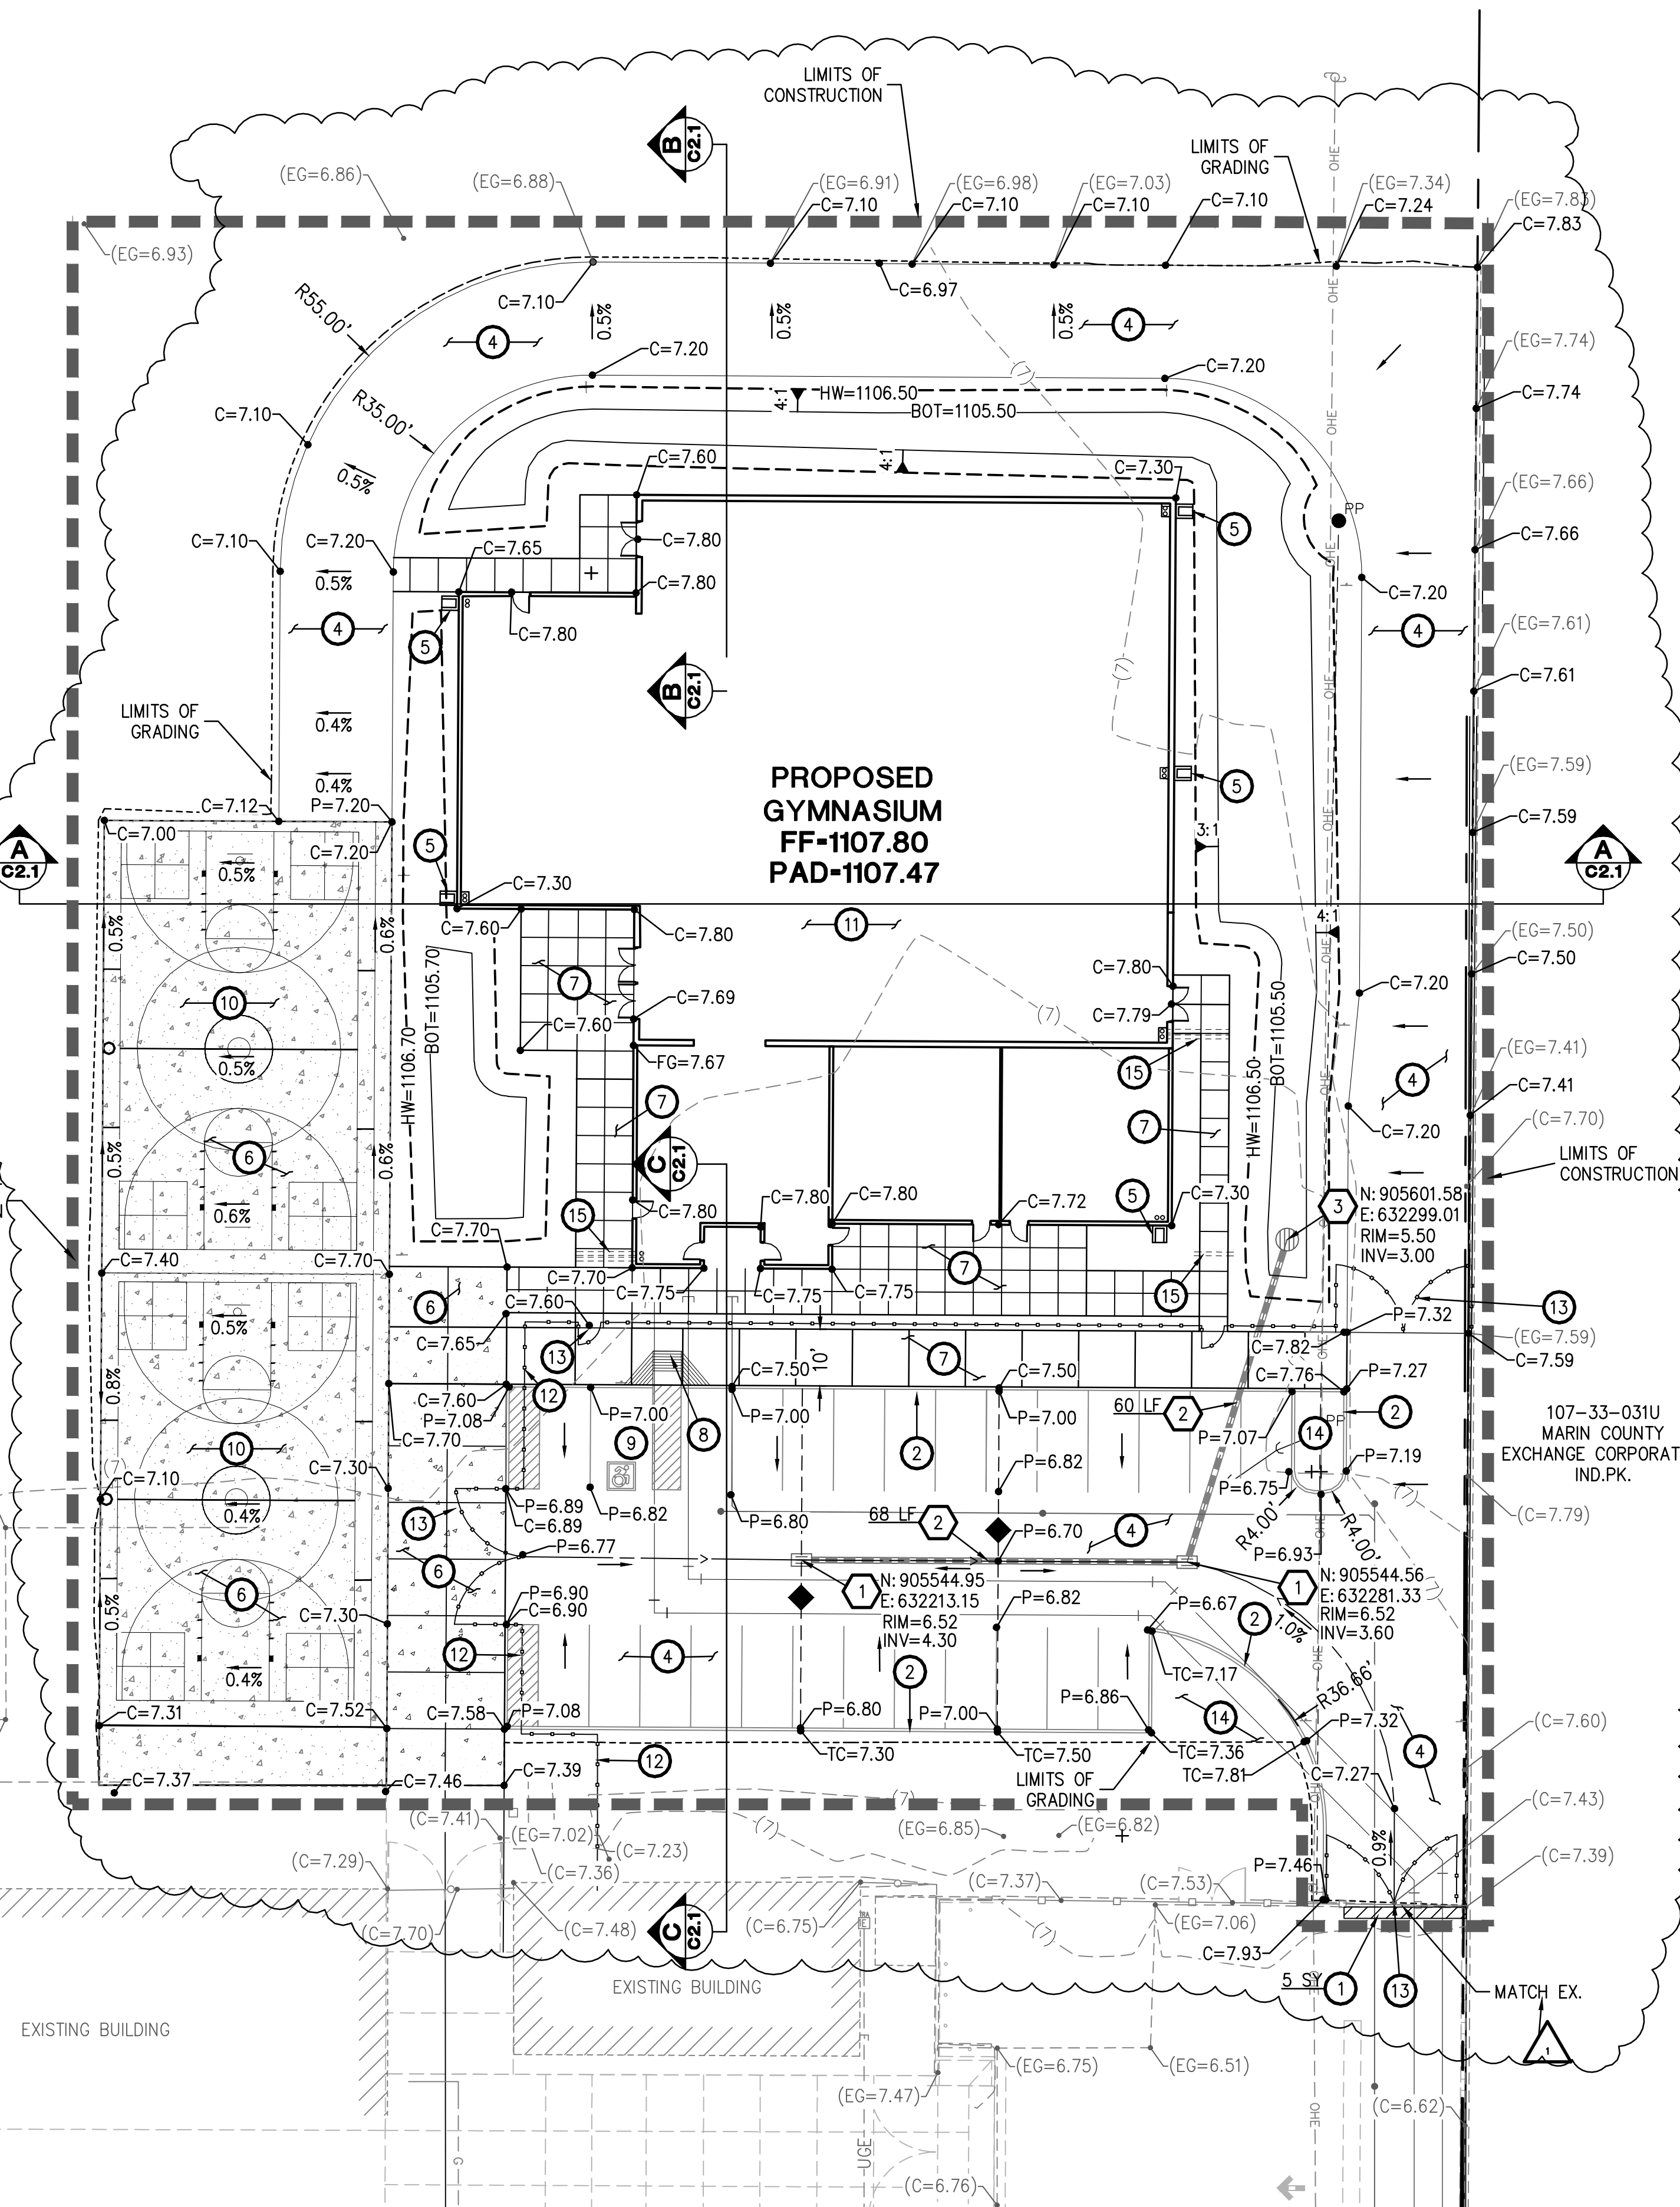
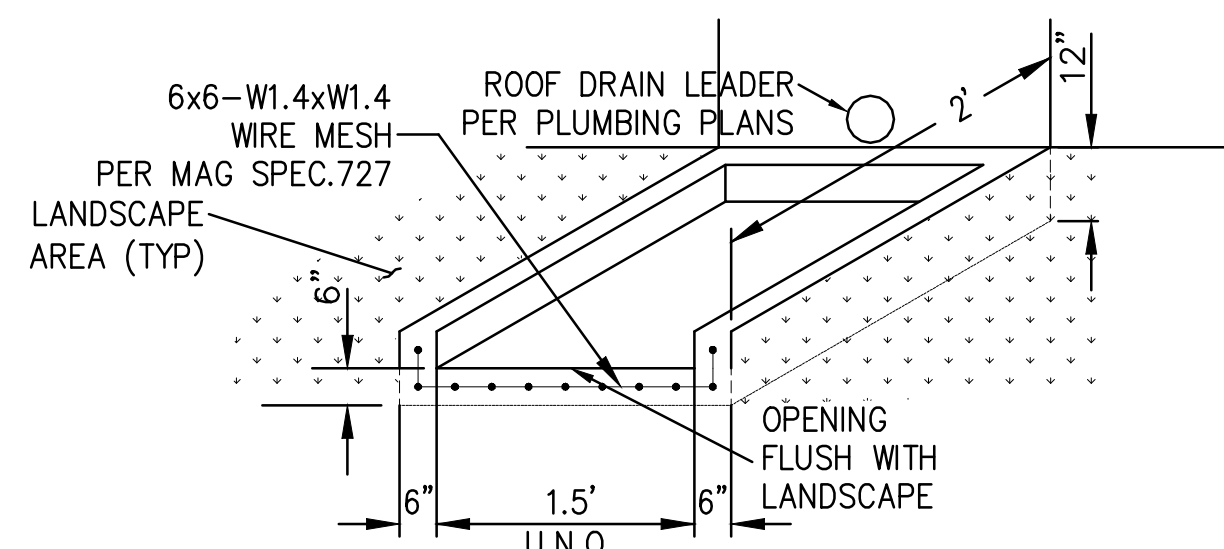
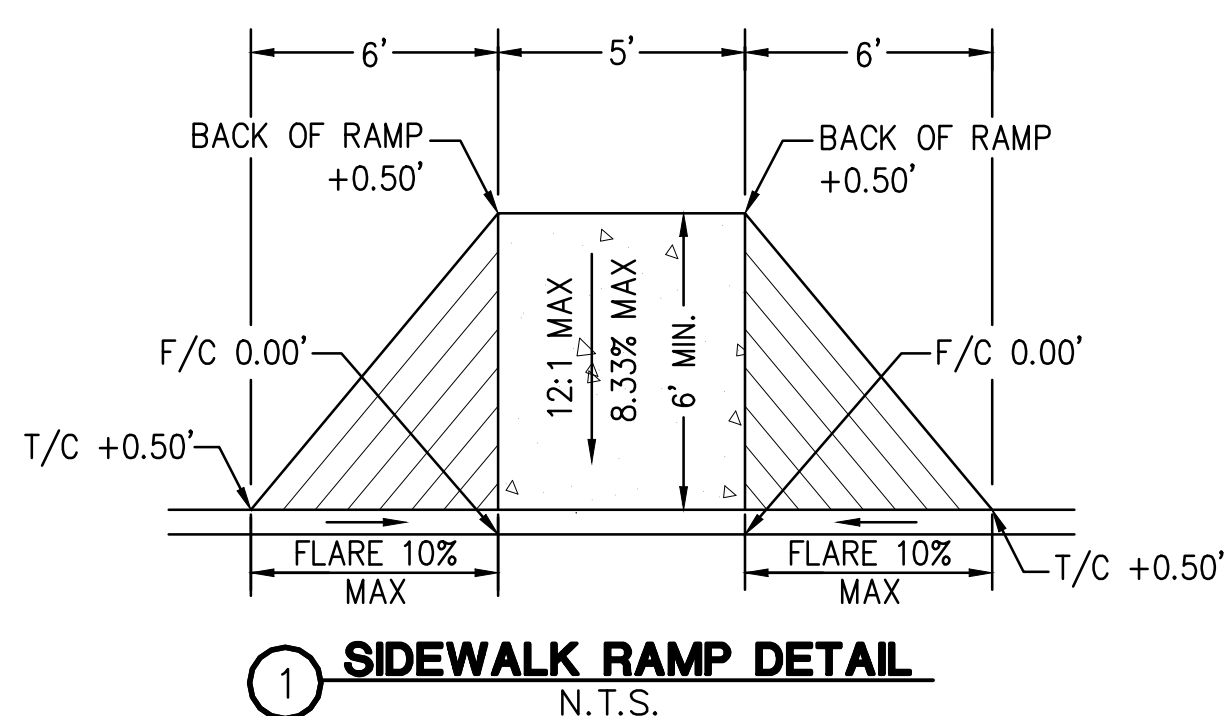
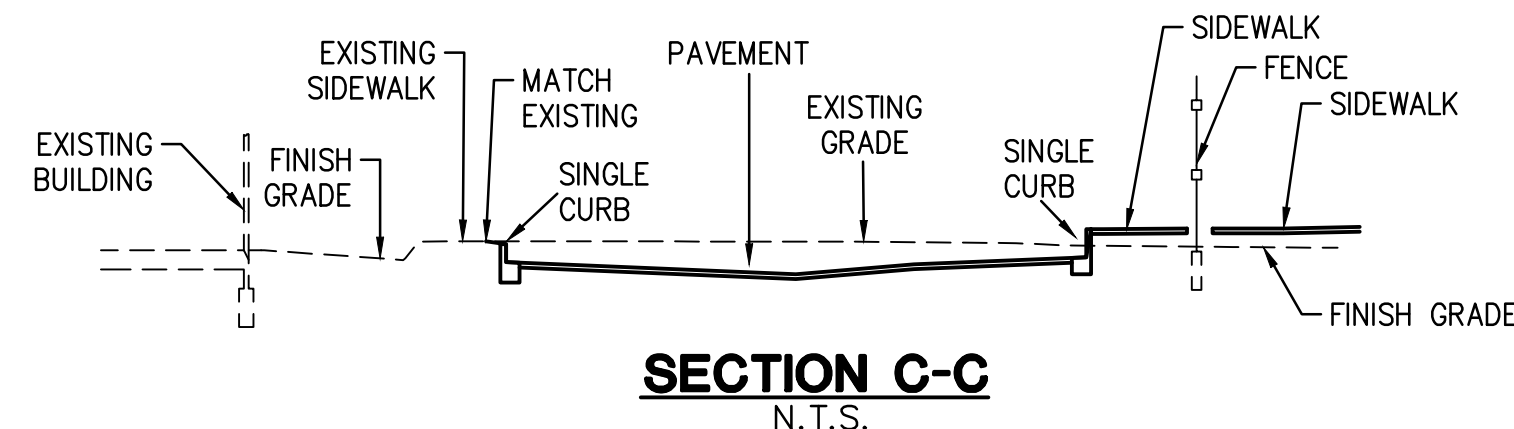
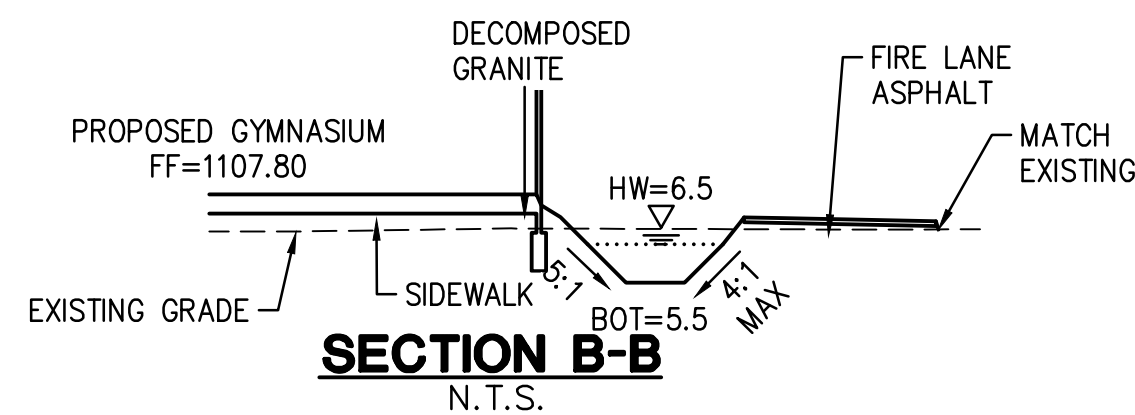


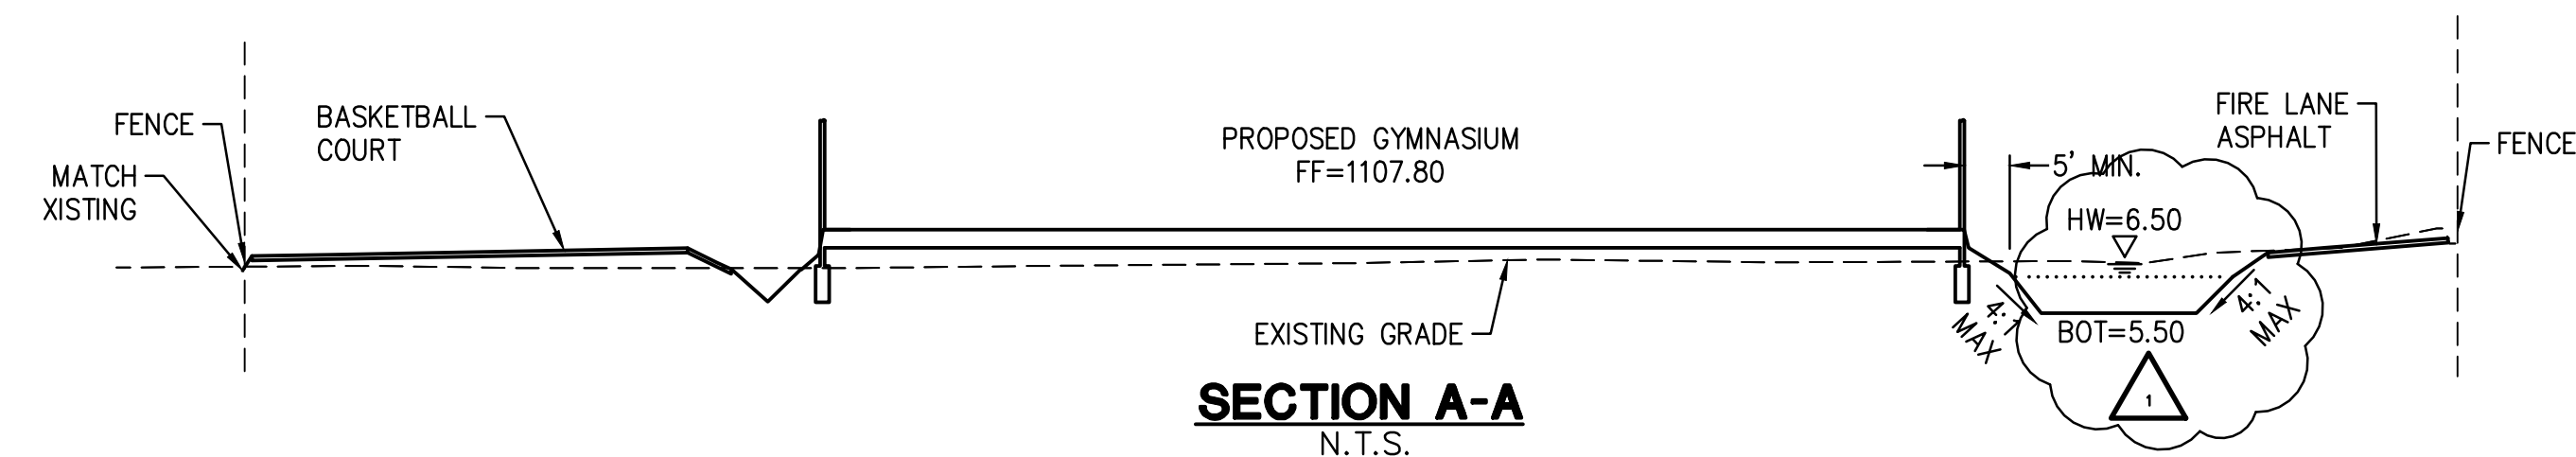


GRADING & DRAINAGE CONSTRUCTION NOTES

- SAWCUT, REMOVE AND REPLACE EXISTING PAVEMENT PER MAG SPEC 336 AND C.O.P. DTL P-1200 TYPE B, OR REPLACE IN KIND, WHICHEVER IS GREATER.
- CONSTRUCT SINGLE CURB PER MAG STD DTL 222 TYPE 'B'.
- INSTALL 3" AC OVER 8" ABC. SEE DETAIL 2 & ON SHEET C1.1.(LIGHT)
- CONSTRUCT CONCRETE SPLASH PAD PER DETAIL 4 ON SHEET C1.1.
- CONSTRUCT 6" THICK CONCRETE PER GEOTECHNICAL REPORT, AND PER MAG SPEC 324, 340 AND 725, CLASS AA. SUBGRADE PREP PER MAG SPEC 301.
- CONSTRUCT CONCRETE SIDEWALK PER C.O.P. STD DTL P1230. (WIDTH PER PLAN).
- CONSTRUCT SIDEWALK RAMP PER DETAIL 1 ON THIS SHEET.
- ADA AREA. SLOPES NOT TO EXCEED 2% IN ANY DIRECTION.
- NEW BASKETBALL COURT AREA.
- CONTRACTOR TO COMPACT ENTIRE AREA OF BUILDING PER SOILS REPORT.
- PROPOSED SITE FENCE. SEE ARCHITECTURAL PLANS FOR DETAILS.
- PROPOSED GATE. SEE ARCHITECTURAL PLANS FOR DETAILS.
- PROPOSED LANDSCAPE AREA - SEE LANDSCAPE PLANS FOR DETAILS.
- INSTALL SIDEWALK SCUPPER PER MAG STD DTL 203, MODIFIED WITH STAINLESS STEEL PLATE AND BOLTS.



STORM DRAIN CONSTRUCTION NOTES

- CONSTRUCT CATCH BASIN PER MAG STD DTL 535 1 EA TYPE 'F'.
- INSTALL 12" HDPE STORM DRAIN PIPE PER MAG SPEC. 738 AND BACKFILL AND COMPACTION PER MAG SPEC 601. 60 LF
- CONSTRUCT BUBBLER BOX PER DETAIL 3 ON THIS SHEET. 1 EA

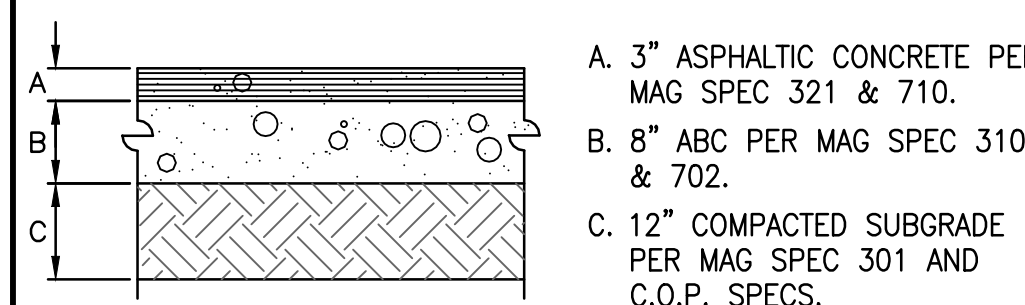

2 LIGHT DUTY PAVEMENT

N.T.S.

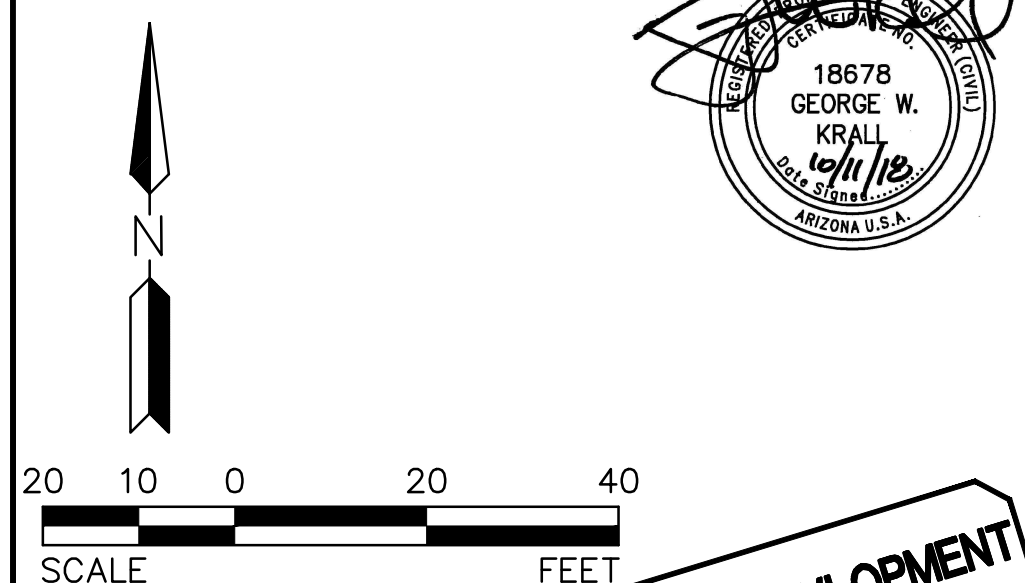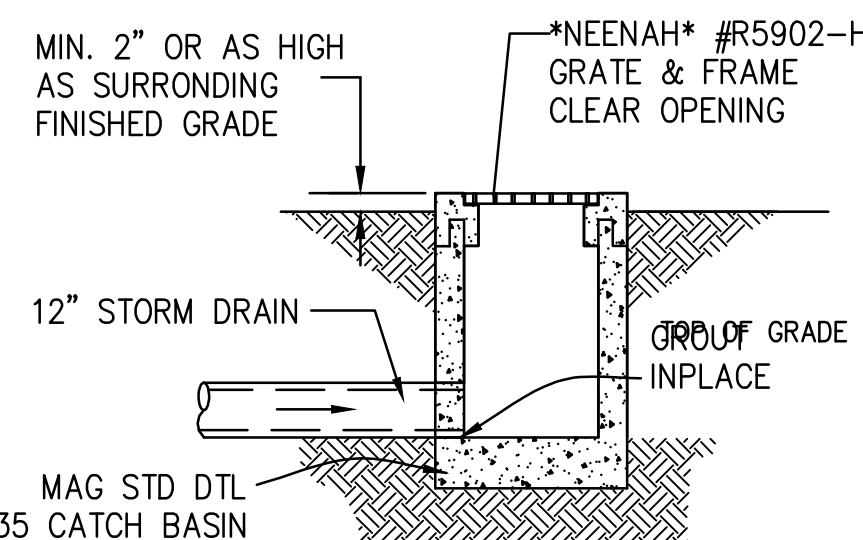

DESIGN DEVELOPMENT
NOT FOR
CONSTRUCTION

NEW MADRID MIDDLE SCHOOL - GYMNASIUM ADDITION
3736 W OSBORN ROAD
PHOENIX, ARIZONA

GRADING & DRAINAGE PLAN

PROJ. NO. 2000		 HILGARTWILSON	
DATE: OCTOBER 2018			
SCALE: AS SHOWN			
DESIGNED: DZ		DRAWN: SA	APPROVED: GK
REV. 1	10-11-2018 SITE REGRADING		DWG. NO.

C1.1

SHT. 2 OF 2

U:\2000\2000\ENGR\PLANS\Cds\2000 - C1.1 G&D.dwg 10/11/2018 3:06 PM